




# GREATER LYNCHBURG TRANSIT COMPANY OPERATIONS AND MAINTENANCE FACILITY

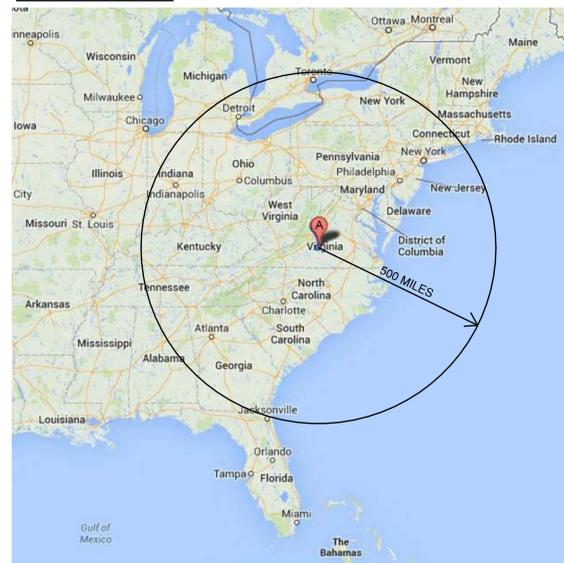

## VICINITY MAP



## PROJECT ADDRESS:

419 Bradley Dr, Lynchburg, VA 24501-4901

## BID DOCUMENTS



1420 King Street, Suite 510  
Alexandria, VA 22314  
www.wendelcompanies.com  
p. 703.299.8718  
f. 703.299.8719



127 Nationwide Drive, Lynchburg, Virginia 24502-4272  
phone 434.947.1901 | fax 434.947.1801 | web wileywilson.com




SEPTEMBER 24, 2014

WENDEL PROJECT # 444505



## LOCATION MAP

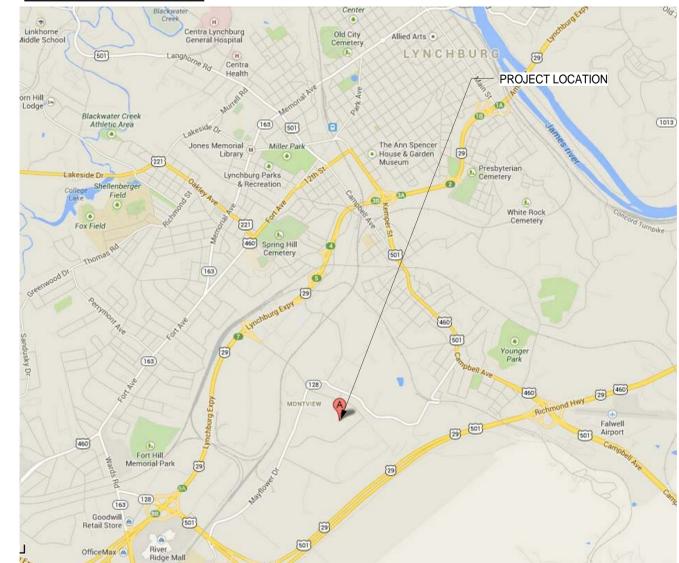



GREATER LYNCHBURG TRANSIT  
COMPANY  
1301 Kenner Street PO Box 707  
Lynchburg, VA 24505-0707

PROJECT ADDRESS:  
419 Bradley Dr,  
Lynchburg, VA  
24501-4901

Operations &  
Maintenance Facility

BID DOCUMENTS



NOTES  
THIS DOCUMENT AND THE DATA AND DESIGN INFORMATION HEREIN ARE AN INSTRUMENT OF PROFESSIONAL SERVICE. IT IS THE PROPERTY OF WENDEL ARCHITECTURE, ENGINEERING, SURVEYING & LANDSCAPE ARCHITECTS, INC. (WENDEL). IT IS TO BE USED ONLY FOR THE PROJECT AND SITE SPECIFICALLY IDENTIFIED HEREIN. IT IS NOT TO BE REPRODUCED, COPIED, REPRODUCED, TRANSMITTED, OR IN ANY MANNER DISSEMINATED WITHOUT THE WRITTEN CONSENT OF WENDEL. ANY REPRODUCTION OR DISSEMINATION WITHOUT THE WRITTEN CONSENT OF WENDEL IS PROHIBITED. WENDEL ARCHITECTURE, ENGINEERING, SURVEYING & LANDSCAPE ARCHITECTS, INC. IS AN EQUAL OPPORTUNITY EMPLOYER. THE NEW YORK STATE EDUCATION LAW.



Revision Number Description Revision Date

INDEX OF DRAWINGS

DATE: 09/24/2014  
SCALE:  
DWG: RAS DWG: PDM  
PROJECT NO.: 444205  
DWG. NO.:

G001

GENERAL DRAWINGS	
SHEET #	SHEET NAME
G000	COVER
G001	INDEX OF DRAWINGS
G002	ABBREVIATIONS, SYMBOLS, ACCESSIBLE MOUNTING DIMENSIONS AND SPECIFICATIONS REFERENCE
G003	CODE COMPLIANCE PLAN

CIVIL DRAWINGS	
SHEET #	SHEET NAME
C101	GENERAL NOTES
C102	EXISTING CONDITIONS
C103	EROSION AND SEDIMENT CONTROL NARRATIVE
C103A	EROSION AND SEDIMENT CONTROL NARRATIVE
C104	EROSION AND SEDIMENT CONTROL PLAN
C104A	EROSION AND SEDIMENT CONTROL PLAN
C105	EROSION AND SEDIMENT CONTROL DETAILS
C106	EROSION AND SEDIMENT CONTROL DETAILS
C201	SITE LAYOUT PLAN
C202	DIMENSIONAL LAYOUT PLAN
C203	SITE GRADING AND UTILITIES PLAN
C301	DRAINAGE MAPS EXISTING AND PROPOSED CONDITIONS
C302	STORMWATER DRAINAGE LAYOUT AND DESIGN PLAN SHEET
C303	STORMWATER/DRAINAGE CALCULATIONS
C303A	STORMWATER/DRAINAGE CALCULATIONS
C304	STORMWATER/DRAINAGE CALCULATIONS
C304A	STORMWATER/DRAINAGE CALCULATIONS
C501	STORMWATER/DRAINAGE DETAILS
C501A	STORMWATER/DRAINAGE DETAILS
C502	DETAILS
C503	DETAILS
C504	DETAILS
C505	DETAILS
C506	SITE DETAILS
C507	SITE DETAILS

LANDSCAPE DRAWINGS	
SHEET #	SHEET NAME
L101	SITE PLANTING PLAN

STRUCTURAL DRAWINGS	
SHEET #	SHEET NAME
S001	STRUCTURAL NOTES AND SCHEDULES
S002	TYPICAL DETAILS
S101	FOUNDATION PLAN / FIRST FLOOR PLAN
S201	ADDITIONAL STEEL SUPPORT FRAMING PLAN
S301	FOUNDATION DETAILS
S401	STRUCTURAL DETAILS

ARCHITECTURE DRAWINGS	
SHEET #	SHEET NAME
A101	FLOOR PLAN OVERALL
A102	PARTIAL FLOOR PLAN - AREA A
A103	PARTIAL FLOOR PLAN - AREA B AND ENLARGED TOILET ROOMS
A104	ENLARGED PLANS
A105	ROOF PLAN
A106	GASOLINE DISPENSER CANOPY AND STORAGE SHEDS (NON-FUEL)
A200	PLAN DETAILS
A300	BUILDING ELEVATIONS
A350	BUILDING SECTIONS
A400	WALL SECTIONS
A401	WALL SECTIONS
A402	WALL SECTIONS
A403	WALL SECTIONS
A404	WALL SECTIONS
A430	ROOF TYPES AND DETAILS
A450	SECTION DETAILS
A451	SECTION DETAILS
A600	INTERIOR ELEVATIONS
A601	INTERIOR ELEVATIONS
A602	INTERIOR ELEVATIONS
A700	REFLECTED CEILING PLAN
A800	MILLWORK DETAILS
A880	CEILING DETAILS
A881	CEILING DETAILS
A901	DOOR SCHEDULE, TYPES AND DETAILS
A902	WALL TYPES AND DETAILS
A903	GLAZING TYPES
A904	CLERESTORY GLAZING TYPES
A905	GLAZING DETAILS
A906	ROOM FINISH SCHEDULE AND DETAILS
A920	DOOR HARDWARE SETS
A921	DOOR HARDWARE SETS
A1000	SIGNAGE - SITE PLAN
A1001	SIGNAGE - FLOOR PLAN
A1002	SIGNAGE - ELEVATIONS
A1003	SIGNAGE - ELEVATIONS
A1004	SIGNAGE - ELEVATIONS
A1005	SIGNAGE - SCHEDULES
A1006	SIGNAGE - SCHEDULES
A1007	SIGNAGE - SCHEDULES

EQUIPMENT DRAWINGS	
SHEET #	SHEET NAME
Q001	EQUIPMENT SYMBOLS, NOTES AND ABBREVIATIONS
Q101	PARTIAL FIRST FLOOR EQUIPMENT PLAN - AREA A
Q201	EQUIPMENT DETAILS
Q301	EQUIPMENT SCHEDULES

PROCESS DRAWINGS	
SHEET #	SHEET NAME
D001	PROCESS SYMBOLS, NOTES, AND ABBREVIATIONS
D101	PARTIAL FIRST FLOOR PROCESS PLAN - AREA A
D102	PARTIAL FIRST FLOOR PROCESS PLAN - UNDERGROUND PIPING - AREA A
D201	PROCESS DETAILS
D202	PROCESS DETAILS
D203	PROCESS DETAILS
D204	PROCESS DETAILS
D301	PROCESS SCHEDULES

PLUMBING DRAWINGS	
SHEET #	SHEET NAME
P001	PLUMBING SYMBOLS, NOTES AND ABBREVIATIONS
P101	PARTIAL FLOOR UNDER SLAB PLUMBING PLAN - AREA A
P102	PARTIAL FLOOR UNDER SLAB PLUMBING PLAN - AREA B
P103	PARTIAL FLOOR PLUMBING PLAN - AREA A
P104	PARTIAL FLOOR PLUMBING PLAN - AREA B
P105	ROOF PLUMBING PLAN
P201	PLUMBING DETAILS
P301	PLUMBING SCHEDULES

FIRE PROTECTION DRAWINGS	
SHEET #	SHEET NAME
FP001	FIRE PROTECTION SYMBOLS, NOTES AND ABBREVIATIONS
FP101	FIRE PROTECTION PARTIAL FIRST FLOOR PLAN AREA A
FP102	FIRE PROTECTION PARTIAL FIRST FLOOR PLAN AREA B
FP201	FIRE PROTECTION DETAILS AND SCHEDULES


HVAC DRAWINGS	
SHEET #	SHEET NAME
H001	HVAC SYMBOLS, NOTES AND ABBREVIATIONS
H101	PARTIAL FIRST FLOOR HVAC PLAN - DUCTWORK - AREA A
H102	PARTIAL FIRST FLOOR HVAC PLAN - DUCTWORK - AREA B
H103	UPPER GARAGE BAY LEVEL HVAC PLAN - DUCTWORK
H104	PARTIAL FIRST FLOOR HVAC PLAN - PIPING - AREA A
H105	PARTIAL FIRST FLOOR HVAC PLAN - PIPING - AREA B
H201	HVAC SECTIONS
H202	HVAC SECTIONS
H203	HVAC DETAILS
H204	HVAC DETAILS
H301	HVAC SCHEDULES
H302	HVAC SCHEDULES
H401	HVAC CONTROL DIAGRAMS
H402	HVAC CONTROL DIAGRAMS
H403	HVAC CONTROL DIAGRAMS
H501	HVAC SCHEMATIC

ELECTRICAL DRAWINGS	
SHEET #	SHEET NAME
E001	ELECTRICAL SYMBOLS, ABBREVIATIONS, & NOTES
E100	ELECTRICAL SITE PLAN
E101	GROUND FLOOR PLAN AREA A - POWER
E102	GROUND FLOOR PLAN AREA B - POWER
E103	GROUND FLOOR PLAN AREA A - LIGHTING
E104	GROUND FLOOR PLAN AREA B - LIGHTING
E105	GROUND FLOOR PLAN AREA A - SYSTEMS
E106	GROUND FLOOR PLAN AREA B - SYSTEMS
E400	ENLARGED PLANS - POWER & SYSTEMS LAYOUTS
E500	LUMINAIRE SCHEDULE AND LIGHTING DETAILS
E501	MECHANICAL EQUIPMENT CONNECTION SCHEDULE
E502	EQUIPMENT CONNECTION SCHEDULE
E503	PANEL BOARD SCHEDULES
E504	PANEL BOARD SCHEDULES
E505	SWITCHBOARD SCHEDULES
E600	SINGLE LINE DIAGRAM
E601	CCTV RISER AND CAMERA MOUNTING DETAILS
E602	INTERCOM, PA, DATA & TV SYSTEMS RISER DIAGRAMS
E603	FIRE ALARM SYSTEM RISER, NOTES & DETAILS
E604	GROUNDING SYSTEM SINGLE LINE DIAGRAM
E700	LIGHTNING PROTECTION LAYOUT
E701	LIGHTNING PROTECTION DETAILS & NOTES
E702	CLASSIFIED AREAS PLAN
E800	ELECTRICAL GROUNDING DETAILS
E801	ELECTRICAL DETAILS
E802	DOOR CONFIGURATION ACCESS CONTROL & SECURITY SYSTEM DETAILS
E803	GENERATOR DETAILS
E804	GASOLINE & DIESEL DISPENSING SCHEMATIC PLAN - POWER
E805	FUEL DISPENSING CONDUIT ROUTING PLAN

**ABBREVIATIONS:**


AB ANCHOR BOLT	FCU FAN COIL UNIT	OC ON CENTER
ABV ABOVE	FD FLOOR DRAIN	OD OUTSIDE DIAMETER
AC ASPHALTIC CONCRETE	FDN FOUNDATION	OF OUTSIDE FACE
ACT AIR CONDITIONING	FE FIRE EXTINGUISHER	OH OTHER FURNISHED-CONTRACTOR INSTALLED
AD ACCESSIBLE	FF FINISHED FLOOR	OP OPENING
ADD ADDENDUM	FFC FIRE EXTINGUISHER CABINET	OS OPPOSITE
ADJ ADJUSTABLE	FFH FACE TO FACE	OPH OPPOSITE HAND
ADUC ADJACENT	FHC FIRE HOSE CABINET	PA PLANTING AREA
AFF ABOVE FINISHED FLOOR	FIN FINISH	PBD PARTICLE BOARD
AFG ABOVE FINISHED GRADE	FL FLASHING	PC PRECAST CONCRETE
AHU AIR HANDLING UNIT	FLR FLOOR	PCF PRECAST CONCRETE PIECE
AL ALUMINUM	FND FEMININE NAPKIN DISPOSAL	PCP POUNDS PER CUBIC FOOT
ALT ALTERNATE/ALTERNATIVE	FNT FEMININE NAPKIN/TAMPON DISPENSER	PE PRE-ENGINEERED METAL BUILDING
AMT AMOUNT	FCC FACE OF CONCRETE	PERF PERFORATED
AMOD ANDOZED	FOM FACE OF MASONRY	PEGB PEGBOARD
APPROX APPROXIMATELY	FR FRAME	PL PLASTER
ARCH ARCHITECT/ARCHITECTURAL	FRGWB FIBER REINFORCED GYPSUM WALL BOARD	PLAS PLASTER
ASSY ASSEMBLY	FS FOOD SERVICE	PLG PLUMBING
AV AUDIO VISUAL	FTT FEET/TWO	PLYWOOD
AWG AMERICAN WIRE GAUGE	FT FT	PREMLOD PREMILLOD EXPANSION JOINT
B/B BACK TO BACK	FTR FINISHED FLOOR	PP POWER POLE
BC BRICK	FURR FURRING	PREFINISHED
BD BOARD	G GAS	PREFAB PREFABRICATED
BTUM BUTYRUM	GA GAUGE	PSF POUNDS PER SQUARE FOOT
B/SPL BACKSPLASH	GAL GALLON	PSI POUNDS PER SQUARE INCH
BLDG BUILDING	GALV GALVANIZED	PT PORTLAND TILE/PAVER TILE
BLK BLOCK	GB GRAB BAR/GRADE BEAM	PTD PAPER TOWEL DISPENSER
BLUC BLOCK COURSE	GC GENERAL CONTRACTOR	PTN PARTITION
BLKG BLOCKING	GCMU GLAZED CONCRETE MASONRY UNIT	PTM PAVEMENT
BM BEAM/BENCH MARK	GDR GROUND RAIL	PVF POLYVINYL CHLORIDE
BRK BRICK	GRD GROUND	QT QUARRY TILE
BS BOTH SIDES	GR GRASS	QTY QUANTITY
BSMT BASEMENT	GRB GYPSUM WALL BOARD	R RADIUS/RISER/THERMAL RESISTANCE
BTWN BETWEEN	GYP GYPSUM	RA RETURN AIR
BTM BOTTOM	H HIGH	RAD RADIATOR
BTU BRITISH THERMAL UNIT	HB HOSE BIBB	RBB RUBBER BASE
BUR BUILT UP ROOF	HC HANDICAPPED	RBR RUBBER
BW BOTH WAYS	HD HAND DRYER	RCC REINFORCED CONCRETE PIPE/REFLECTED CEILING
C CHANNEL	HDW HARDWARE	RD ROOF DRAIN
CAB CABINET	HM HOLLOW METAL	REC RECEPTACLE
CB CATCH BASIN	HRZ HORIZONTAL	REF REFRIGERANT
CC CENTER OF CENTER	HPR HIGH POINT/HORSEPOWER	REF REFRIGERATOR
CEM CEMENT	HR HOUR	REF REFRIGERATOR
CG CERAMIC GLAZED TILE	HT HEIGHT	REF REFRIGERATOR
CH CHALK BOARD	HVAC HEATING, VENTILATING AIR CONDITIONING	REF REFRIGERATOR
CHD CAST IRON	HYD HYDRANT	REF REFRIGERATOR
CJ CONTROL JOINT	ID INSIDE DIAMETER	RES RESILIENT
CL CENTER LINE	IF INSIDE FACE	RET RETURN
CLG CEILING	IM IMP	RFG ROOF FLASHING
CLK CHAIN LINK	IN INCH	RHF ROOF HATCH
CLL CONTINUOUS LIMIT LINE	INCL INCLUDING, INCLUDED	RHS REFLECTED CEILING PLAN
CLO CLOSET	IND INDICATED	RH RIGHT HAND
CLM CLASSROOM	INSUL INSULATION/INSULATED	RHR RIGHT HAND REVERSE
CLS CLOSURE	INT INTERIOR	RL ROOM
CLM CORRUGATED METAL PIPE	INV INVERT	RO ROUGH OPENING
CMT CERAMIC MOSAIC TILE	IP IRON PIPE SIZE	ROV RIGHT OF WAY
CMU CONCRETE MASONRY UNIT	IPS IRON PIPE SIZE	RR RAILROAD
CON CONDUIT	JAN JANITOR	RST RUBBER STAR TREAD
COB CONCRETE BLOCK	JT JOINT	RTU ROOF TOP UNIT
COL COLUMN	JST JOIST	RV ROOF VENT
COMB COMBINATION	LAB LABORATORY	S SOUTH
COMP COMPOSITION	LAM LAMINATED	SA SANITARY DRAINAGE LINE/SUPPLY AIR
CONC CONCRETE	LAV LAVATORY	SC SPECIAL COATINGS/SOLID CORE
COND CONDENSER	LB POUND	SCD SEAT COVER DISPENSER
CONF CONFERENCE	LF LINEAR FEET/LINEAR FOOT	SCHE SCHEDULE
CONN CONNECTION	LG LENGTH	SD SOAP DISPENSER
CONST CONSTRUCTION	LH LEFT HAND	SECT SECTION
CONT CONTINUOUS	LHR LEFT HAND REVERSE	SF SQUARE FOOT/SQUARE FEET
CONTR CONTRACTOR	LIN LINEAR	SGFT SQUARE FOOT
COORD COORDINATE	LKR LOCKER	SHR SHEET
CORR CORRUGATED	LL LONG LEG HORIZONTAL	SHR SHEATHING
CP CONCRETE PIPE	LLV LONG LEG VERTICAL	SHV SHEATHING
CPT CARPET	LL LEVEL LOAD	SIM SIMILAR
CRPS COMPRESSIBLE	LOC LOCATION	SEL SELANT
CRS COLD ROLLED STEEL	LP LOW POINT	SP SPACE/STAND PIPE
CS COUNTER SHUTTER	LT LIGHT	SPC SPECIFICATIONS
CST CERAMIC TILE	LVR LOUVER	SS STAINLESS STEEL
CUST CUSTODIAN	MAR MARBLE	ST STORM DRAINAGE LINE
D DEPTH	MAS MASONRY	STC SOUND TRANSMISSION COEFFICIENT
DBL DOUBLE	MAT MATERIAL	STD STANDARD
DBLT DOUBLE TEE	MAX MAXIMUM	STL STEEL
DEMO DEMOLISH/DEMOLITION	MB MACHINE BOLT	STR STRUCTURAL
DEPT DEPARTMENT	MBH MOP AND BROOM HOLDER	SUSP SUSPENDED
DET DETAIL	MC MISCELLANEOUS CHANNEL	STN STAIN AND VARNISH
DF DRINKING FOUNTAIN	MECH MECHANICAL	SV SHEET VINYL
DH DOUBLE	MED MEDIUM	SYM SYMMETRICAL
DI DROP INLET	MET METAL	T TREAD
DIA DIAMETER	MEZZ MEZZANINE	TB TOWEL BAR/TEST BORING
DIFF DIFFUSER	MFG MANUFACTURING	T&B TOP AND BOTTOM
DIM DIMENSION	MFR MANUFACTURER	TC TOP OF CURB
DISP DISPENSER	MHT MOUNTING HEIGHT	TD TRENCH DRAIN/TOWEL DISPENSER
DN DOWN	MIN MINIMUM	TDD TOWEL DISPENSER AND DISPOSAL
DO DITTO	MISC MISCELLANEOUS	TEL TELEPHONE
DP DEMOUNTABLE PARTITION	ML MATCH LINE	TER TERRAZZO
DR DOWN SPOUT	MO MASONRY OPENING	TER TONGUE & GROOVE
DS DRYWALL	MR MIRROR	THK THICK
DWG DRAWING	MT METAL THRESHOLD	TMB TACK BOARD
DWR DRAWER	MTD MOUNTED	TMR TILTING MIRROR
E EAST	MTP METAL TOILET PARTITION	TOC TOP OF CONCRETE
EA EACH	MW MONITORING WELL	TOF TOP OF FOOTING
EAC EXPOSED CONSTRUCTION	MWU MILLWORK UNIT	TOJ TOP OF JOIST
EF EXHAUST FAN/EACH FACE	N NORTH	TOP TOP OF PIER
EFS EXTERIOR INSULATION & FINISH SYSTEM	NA NOT APPLICABLE	TOP TOP OF STEEL
EXP EXPANSION JOINT	NIC NOT IN CONTRACT	TOP TOP OF WALL
ELECT ELEVATION	NO NUMBER	TOP TOP OF PAVEMENT
ELEV ELEVATOR	NOM NOMINAL	TS TRAFFIC STRIPING
ENCL ENCLOSURE	NRC NOISE REDUCTION COEFFICIENT	TSCD TOILET SEAT COVER DISPENSER
EQ EQUIPMENT BY OTHER	NTS NOT TO SCALE	TTH TOILET TISSUE HOLDER
EP ELECTRICAL PANEL	UC UNDERCUT	TYP TYPICAL
EPDM ETHYLENE PROPYLENE DIENE MONOMER	UCL UNDER CABINET LIGHT	
EQ EQUAL	UG UNDERGROUND	
EQUIP EQUIPMENT	UH UNIT HEATER	
ES EDGE STRIP	UNFIN UNFINISHED	
EW EACH WAY	UNO UNLESS NOTED OTHERWISE	
E/W EASTWEST	UR URINAL	
ENC ELECTRIC WATER COOLER	UTIL UTILITY	
EXC EXCAVATE/EXCAVATION	VCT VINYL COMPOSITION TILE	
EXIST EXISTING	VERT VERTICAL	
EXP EXPANSION	VEST VESTIBULE	
EXT EXTERIOR	VGB VERTICAL GRAB BAR	
EXTR EXTRUDED/EXTRUSION	VL VENT THROUGH ROOF	
	VTR VENT THROUGH ROOF	
	VWC VINYL WALL COVERING	
	W WESTWIDE FLANGE/WIDE	
	W/ WITHOUT	
	WO WOOD	
	WC WATER CLOSET	
	WD WATER GAUGE	
	WG WIRE GLASS	
	WGL WIRE GLASS	
	WL WATER LINE	
	WOM WOMEN	
	WS WEATHER-STRIPPING	
	WSC WAINSCOT	
	WT WEIGHT/TEE CUT FROM W SHAPE	
	WWF WELDED WIRE FABRIC	

**ACCESSIBLE MOUNTING DIMENSIONS:**

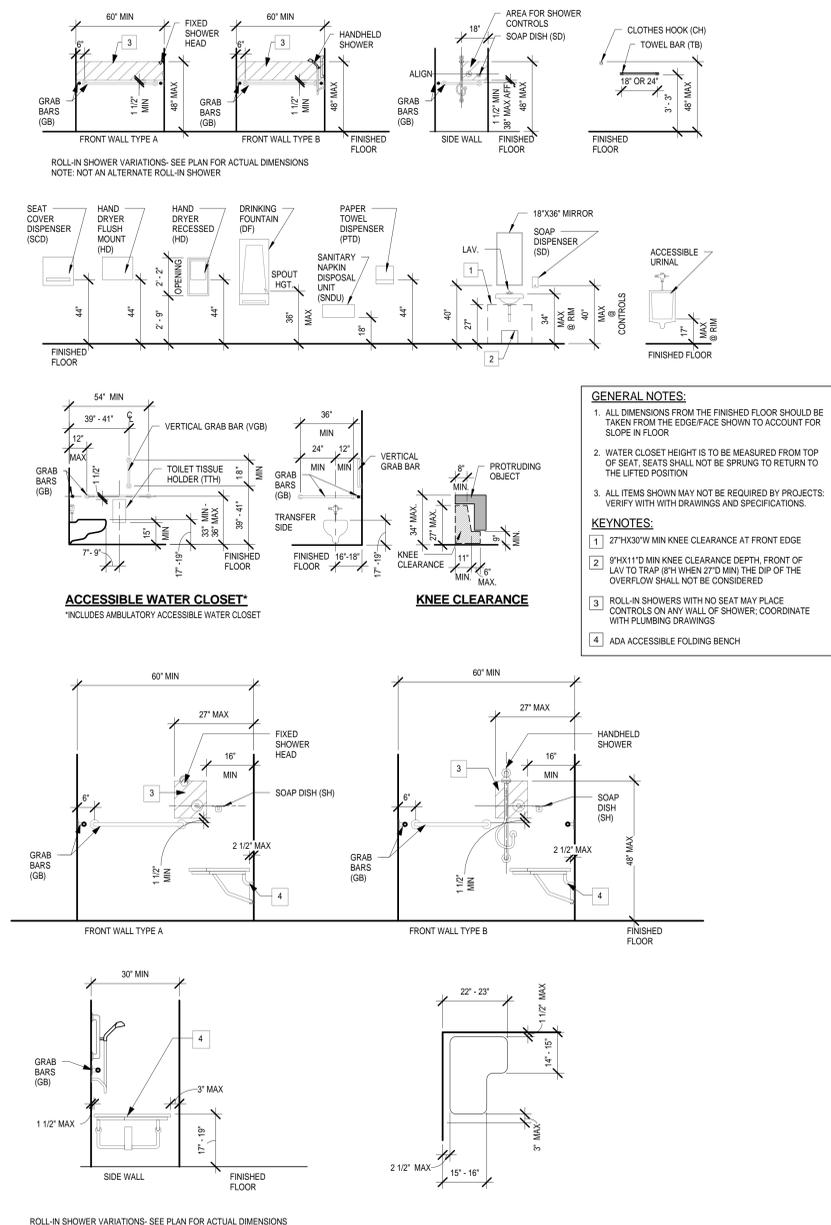


**SYMBOLS:**

	BRICK
	CONCRETE MASONRY UNIT
	INSULATION - RIGID
	INSULATION - THERMAL - ACOUSTIC
	WOOD-STRUCTURAL
	GYPSUM BOARD/PLASTER/GROUT
	CERAMIC TILE
	CONCRETE - PRECAST - POURED IN PLACE
	METAL IN ELEVATION
	ACOUSTICAL CEILING TILE OR PANEL
	BRICK IN ELEVATION
	PLYWOOD
	EARTH
	METAL-FERROUS
	METAL-NON-FERROUS
	TRAFFIC COATING CIRCULATION PATH

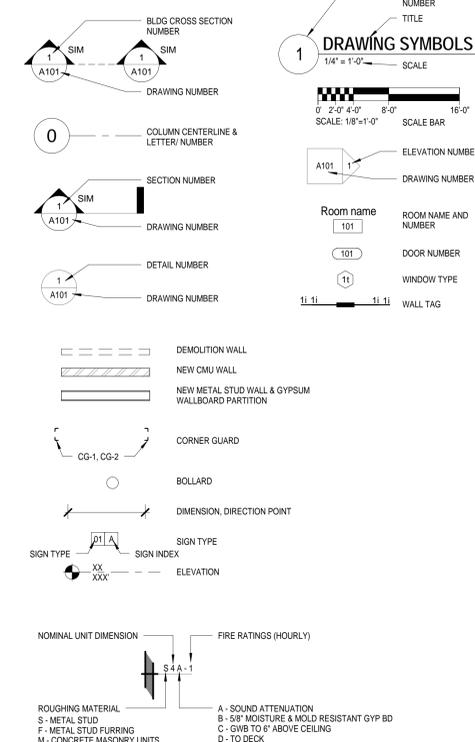

**SPECIFICATIONS REFERENCE:**

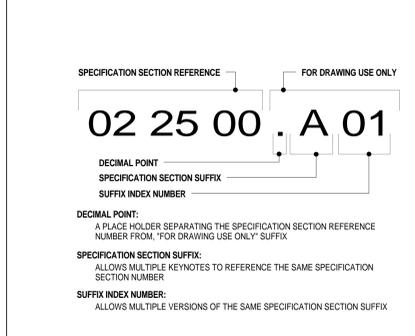

**GREATER LYNCHBURG TRANSIT COMPANY**  
1301 Kemper Street PO Box 707  
Lynchburg, VA 24505-0707

**PROJECT ADDRESS:**  
419 Bradley Dr,  
Lynchburg, VA  
24501-4901

Operations & Maintenance Facility

BID DOCUMENTS



ALEXANDRIA ARCHITECTURE, ENGINEERING,  
LAND SURVEYING & LANDSCAPE ARCHITECTS, INC



NOTES:  
THESE DRAWINGS AND THE DETAILS ARE THE PROPERTY OF WENDEN & PHILIP DOUGLAS ARCHITECTS, P.C. ANY REPRODUCTION OR TRANSMISSION OF THESE DRAWINGS WITHOUT THE WRITTEN PERMISSION OF WENDEN & PHILIP DOUGLAS ARCHITECTS, P.C. IS PROHIBITED. ANY REPRODUCTION OR TRANSMISSION OF THESE DRAWINGS WITHOUT THE WRITTEN PERMISSION OF WENDEN & PHILIP DOUGLAS ARCHITECTS, P.C. IS PROHIBITED. ANY REPRODUCTION OR TRANSMISSION OF THESE DRAWINGS WITHOUT THE WRITTEN PERMISSION OF WENDEN & PHILIP DOUGLAS ARCHITECTS, P.C. IS PROHIBITED.



DATE: 09/24/2014  
SCALE: As Indicated  
DWG: RAS  
PLOT: 444205

ABBREVIATIONS,  
SYMBOLS, ACCESSIBLE  
MOUNTING DIMENSIONS  
AND SPECIFICATIONS  
REFERENCE

DATE: 09/24/2014  
SCALE: As Indicated  
DWG: RAS  
PLOT: 444205

**G002**

